

Addendum #3

Date: September 17, 2018
Project: DEARNG Contract No. 2018-07
BBTS Infrastructure Utilities Project

The work herein shall be considered part of the bid documents for the referenced project and carried out in accordance with the following supplemental instructions issued in accordance with the Contract Documents without change in Contract Sum or Contract Time. Acknowledge receipt of addendum on the bid form as indicated.


Changes to Drawings:

1. *Drawing 1.5 Electrical and IT Duct Bank Details* – Added typical quazite box detail and typical outdoor conduit installation detail. See revised drawing attached.
2. *Drawing 9.3 Alternate #1 Electrical Single Line Diagram New Work* – Added a second general note, “** On this sheet, base bid to include all new exterior conduit(s), and all new conduit(s) to be terminated on the interior of their respective buildings as applicable. All other new work is to be part of alt#1.” Revised Alt#1 clouding of single line diagram. See revised drawing attached.
3. *Drawing 9.4 Alternate #1 Electrical Details* – Revised typical outdoor conduit installation detail. Changed the name of typical duct bank detail to typical quazite box detail. See revised drawing attached.
4. *Drawing 14.3 Information Technology Details* – Changed the name of typical duct bank detail to typical quazite box detail. No revised drawing or sketch issued to reflect this change.

Questions and Answers

1. Detail on 9.4 typ. outdoor conduit install - With base bid the comms conduit will install in this way ? With ALT. #1 Will the power conduits install the same way ?
 - a. All conduits to be installed as shown on typ. outdoor conduit installation detail unless otherwise shown or noted on the drawings.
2. Will conduits enter all buildings the same way per the detail on 9.4 ?
 - a. See answer to question #1 above.

END

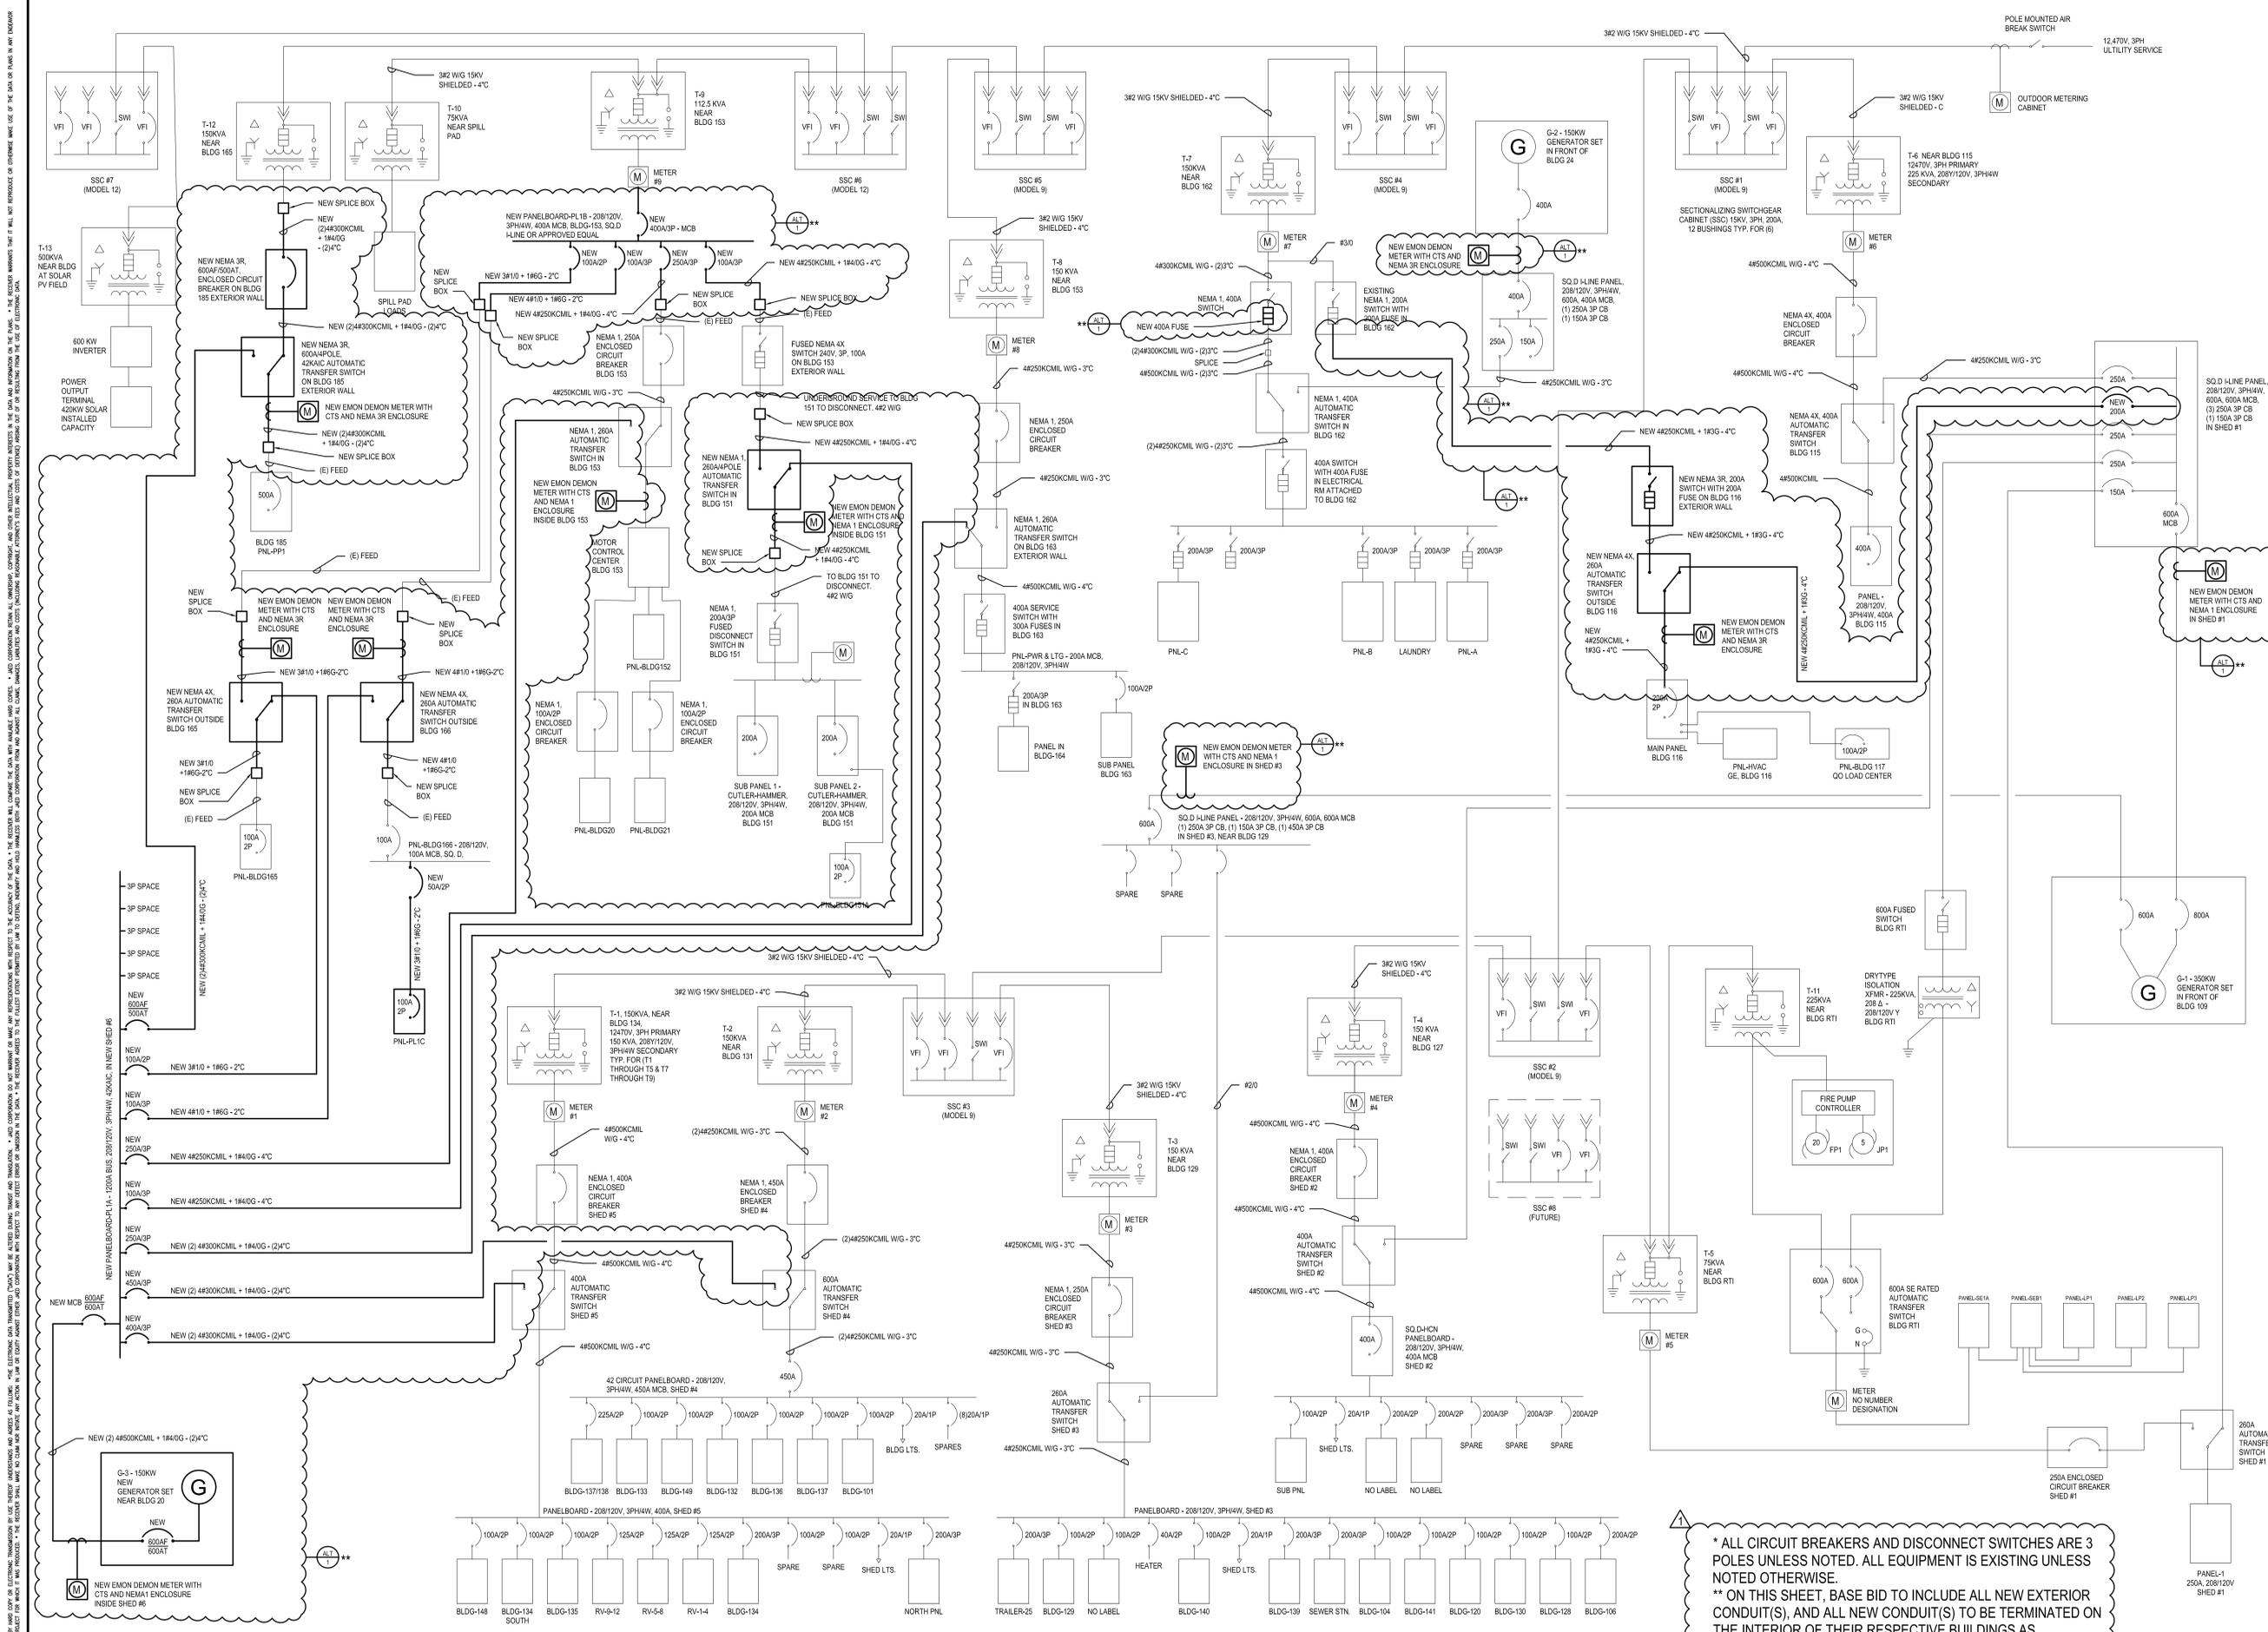

* ALL CIRCUIT BREAKERS AND DISCONNECT SWITCHES ARE 3 POLES UNLESS NOTED. ALL EQUIPMENT IS EXISTING UNLESS NOTED OTHERWISE.
 ** ON THIS SHEET, BASE BID TO INCLUDE ALL NEW EXTERIOR CONDUIT(S), AND ALL NEW CONDUIT(S) TO BE TERMINATED ON THE INTERIOR OF THEIR RESPECTIVE BUILDINGS AS APPLICABLE. ALL OTHER NEW WORK IS TO BE PART OF ALT#1.

1 ELECTRICAL SINGLE LINE DIAGRAM - NEW WORK
 9.3 SCALE: NOT TO SCALE

ARCHITECT / ENGINEER SEAL
 This drawing is the property of StudioJAED and is prepared for the exclusive use of its clients at the location indicated. No other use is authorized or intended.

STUDIOJAED
 ARCHITECTS ■ ENGINEERS ■ FACILITIES SOLUTIONS
 CORPORATE HEADQUARTERS
 2500 WIRANGE HILL ROAD, STE. 110
 BEAR, DE 19701
 P: (302) 832-1423 F: (302) 832-1423
 E-Mail: info@studiojaed.com
 Website: www.studiojaed.com

REVISIONS

▲	ADDENDUM #3	09-17-2018
---	-------------	------------

DELAWARE ARMY NATIONAL GUARD
 PROJECT # FMO-27845
 INFRASTRUCTURE UTILITIES UPGRADES
 DELAWARE ARMY NATIONAL GUARD
 BETHANY BEACH TRAINING SITE
 163 SCANNELL BOULEVARD
 BETHANY BEACH, DELAWARE 19330

ALTERNATE #1 -
 ELECTRICAL SINGLE
 LINE DIAGRAM - NEW
 WORK
 BIDDING DOCUMENTS
 JULY 25, 2018
 DRAWN: JD
 DISCIPLINE: E
 CHECK/DRAWN: PP
 SHEET NO.: 9.3
 PROJECT NO.: 18002

THE RECORD OF THIS DRAWING IS THE PROPERTY OF STUDIOJAED. ANY REPRODUCTION OR USE OF THIS DRAWING WITHOUT THE WRITTEN PERMISSION OF STUDIOJAED IS STRICTLY PROHIBITED. THE RECORD OF THIS DRAWING IS THE PROPERTY OF STUDIOJAED. ANY REPRODUCTION OR USE OF THIS DRAWING WITHOUT THE WRITTEN PERMISSION OF STUDIOJAED IS STRICTLY PROHIBITED. THE RECORD OF THIS DRAWING IS THE PROPERTY OF STUDIOJAED. ANY REPRODUCTION OR USE OF THIS DRAWING WITHOUT THE WRITTEN PERMISSION OF STUDIOJAED IS STRICTLY PROHIBITED.

