

ADDENDUM NO. 1 ISSUED BY

ABHA Architects
1621 N. Lincoln Street
Wilmington, Delaware 19806

NOTICE: Attach this Addendum to the Project Manual for this project. It modifies and becomes a part of the Contract Documents. Work or materials not specifically mentioned herein are to be as described in the main body of the Specifications and as shown on the Drawings. Acknowledge receipt of the Addendum in the space provided on the Bid Form.

This Addendum includes the following (3 pages total including attachments):

CHANGES TO DRAWINGS

ATTACHMENTS:

DRAWINGS CM-03, E-100.

CHANGES TO DRAWINGS

DRAWING G-100

Delete Drawing E-001 from Drawing List.

Change Sheet Number for Electrical Site Plan from E-101 to E-100.


DRAWING E-100

Add Drawing E-100, attached to this Addendum.

DRAWING CM-03

Add Drawing CM-03, attached to this Addendum. Coordinate patching and traffic control requirements for conduit crossing at Orange Street with the City of Wilmington and DelDOT.


END OF ADDENDUM NO. 1

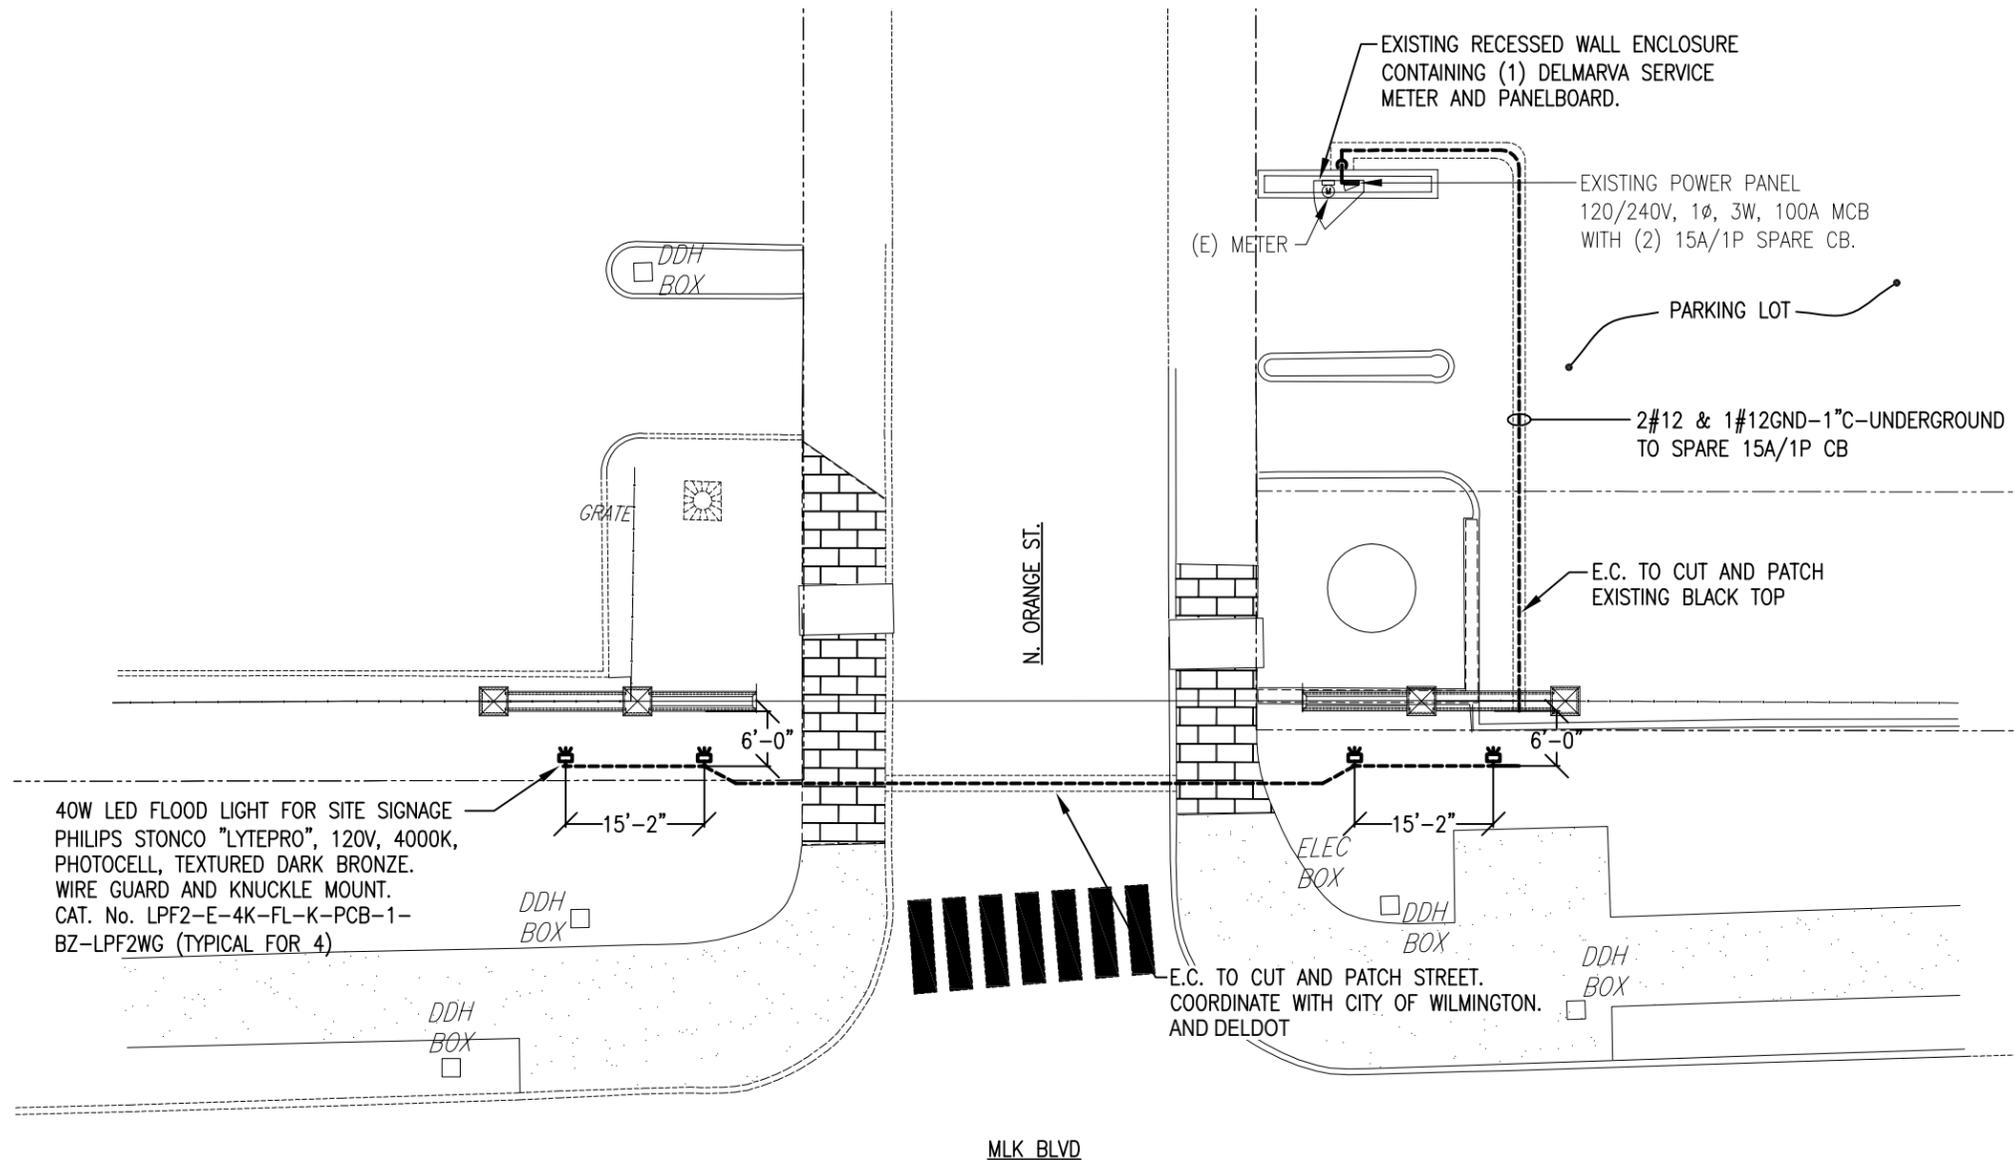

ELECTRICAL NOTES

1. ALL WORK SHALL COMPLY WITH THE LATEST EDITIONS OF THE NATIONAL ELECTRICAL CODE, OSHA, BOCA, NFPA AND ANY APPLICABLE LOCAL CODES/ORDINANCES AS LISTED IN THE SPECIFICATIONS.
2. AN INSULATED GROUND WIRE, SIZED PER THE NEC., SHALL BE PULLED IN ALL RACEWAYS.
3. EACH CIRCUIT SHALL HAVE A SEPARATE NEUTRAL CONDUCTOR, SHARED NEUTRAL CONDUCTORS NOT PERMITTED.
4. THE CONTRACTOR SHALL PROVIDE, INSTALL AND MAKE OPERATIONAL THE ELECTRICAL SYSTEMS & EQUIPMENT ASSOCIATED WITH THE WORK DESCRIBED IN THE BID DOCUMENTS FOR THIS PROJECT.
5. ANY NEW JUNCTION/PULL BOXES INSTALLED SHALL HAVE CIRCUIT NUMBERS WRITTEN ON BOX EXTERIORS.
6. WIRE AND CONDUIT SIZES INDICATED ON HOMERUNS SHALL BE CONTINUOUS THROUGH CIRCUIT.
7. THE ELECTRICAL CONTRACTOR SHALL FURNISH AND INSTALL ALL INCIDENTAL ACCESSORIES NECESSARY TO MAKE THE ELECTRICAL WORK COMPLETE AND READY FOR OPERATION.
8. DRAWINGS ARE DIAGRAMMATIC ONLY: EXACT LOCATION, MOUNTING HEIGHTS OF EQUIPMENT AND ROUTING OF RACEWAYS SHALL BE COORDINATED WITH THE EQUIPMENT REQUIREMENTS AND FIELD CONDITIONS.
9. THE CONTRACTOR SHALL PROVIDE AND INSTALL ALL NECESSARY SUPPORTS AND HARDWARE FOR MOUNTING OF ELECTRICAL EQUIPMENT INCLUDED IN THIS PROJECT.
10. THE ENTIRE ELECTRICAL SYSTEM SHALL BE TESTED FOR PROPER GROUNDING AND OPERATION PRIOR TO FINAL ACCEPTANCE AS SPECIFIED IN THE BID SPECIFICATIONS AND/OR AS SPECIFIED HEREIN. TESTS SHALL VERIFY THAT THE ENTIRE ELECTRICAL SYSTEM HAS NO SHORT-CIRCUITS, OPENS, OVERLOADS, OR PANEL UNBALANCES. ALL EQUIPMENT AND WIRING SYSTEMS SHALL BE GROUNDED IN ACCORDANCE WITH THE REQUIREMENTS OF THE NEC.
11. ALL ELECTRICAL MATERIALS AND EQUIPMENT FURNISHED FOR THIS PROJECT SHALL BE NEW AND APPROVED BY U.L., EXCEPT WHERE NOTED.
12. THE E.C. SHALL SUBMIT "AS-BUILT" DRAWINGS WHEN THE PROJECT IS COMPLETE.

1 SIGN LIGHTING PLAN
E-100 SCALE : 1"=20'-0"

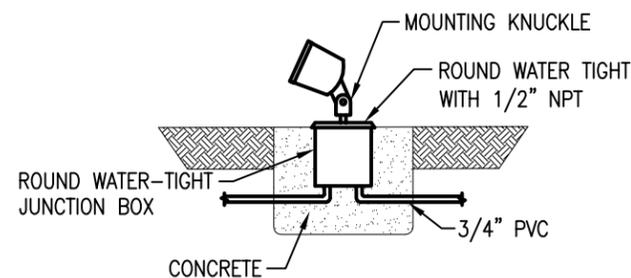


2 FLOOD LIGHT MOUNTING DETAIL
E-100 SCALE : NONE

| | | | |
|---|---|--|--------------|
|  | 1621 N. Lincoln Street Wilmington, DE 19806 (P)302-658-6426 (F)302-658-8431 | SHEET TITLE ELECTRICAL: SIGN LIGHTING PLAN | |
| | abhagen@ABHA.com www.ABHA.com | PROJECT DELAWARE TECHNICAL & COMMUNITY COLLEGE GEORGE CAMPUS EXTERIOR SIGNAGE | |
| REV: ADDENDUM No. 1 ISSUE: 06/01/15 PROJECT NO: 1501 FILE NAME: I1501-E-100.DWG DRAWN BY: MJS CHECKED BY: LE | CONSULTANT PARAGON ENGINEERING CORPORATION 708 PHILADELPHIA PIKE, WILMINGTON, DE 19810 302-762-6010 | | E-100 |

THIS DRAWING AND THE DESIGN SHOWN ARE THE EXCLUSIVE PROPERTY OF LANDMARK SCIENCE AND ENGINEERING AND SHALL NOT BE ALTERED OR COPIED WITHOUT WRITTEN PERMISSION.


THIS DRAWING DOES NOT INCLUDE NECESSARY COMPONENTS FOR CONSTRUCTION SAFETY.

ALL CONSTRUCTION MUST BE DONE IN COMPLIANCE WITH THE OCCUPATIONAL SAFETY AND HEALTH ACT OF 1970 AND THE RULES AND REGULATIONS THERETO APPURTENANT

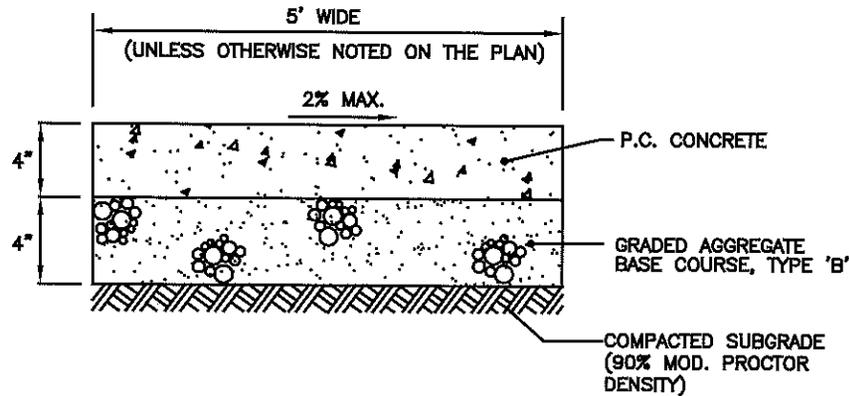

CONCRETE SIDEWALK

NO SCALE

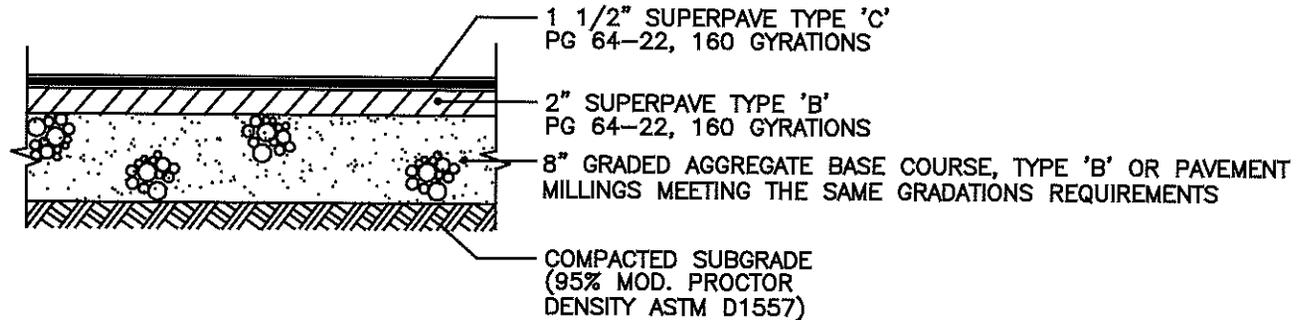

PAVING SECTION (PATCHING)

NO SCALE



Know what's below.
Call before you dig.

MISS UTILITY PHONE 1-800-282-8666
PROTECT YOURSELF, GIVE THREE WORKING DAYS NOTICE

| | |
|---------------------------------|----------------------|
| DRAWN BY: ARP | SCALE: NO SCALE |
| DESIGNED BY: TCW | DATE: 6-2-15 |
| CHECKED BY: TCW | LAST MODIFIED 6/2/15 |
| COMM. NO. C612-4 | FILE NO. |
| DRAWING NAME: EXTERIOR SIGN.DWG | |
| CM-03 | SHEET NO. |
| | CM-01 of 01 |



100 WEST COMMONS BOULEVARD, SUITE 301
NEW CASTLE, DELAWARE 19720
PHONE - (302) 323-9377 • FAX - (302) 323-9461
INFO @ LANDMARK-SE.COM • WWW.LANDMARK-SE.COM

NEW CASTLE, DE
(302) 323-9377

DOVER, DE
(302) 734-9597

HAVRE DE GRACE, MD
(410) 939-2144

EXTERIOR SIGNS

FOR

DELAWARE TECHNICAL &
COMMUNITY COLLEGE
ORLANDO J. GEORGE JR. CAMPUS
NEW CASTLE HUNDRED - NEW CASTLE COUNTY, DELAWARE